

Proposed Stores Building for SCT Logistics

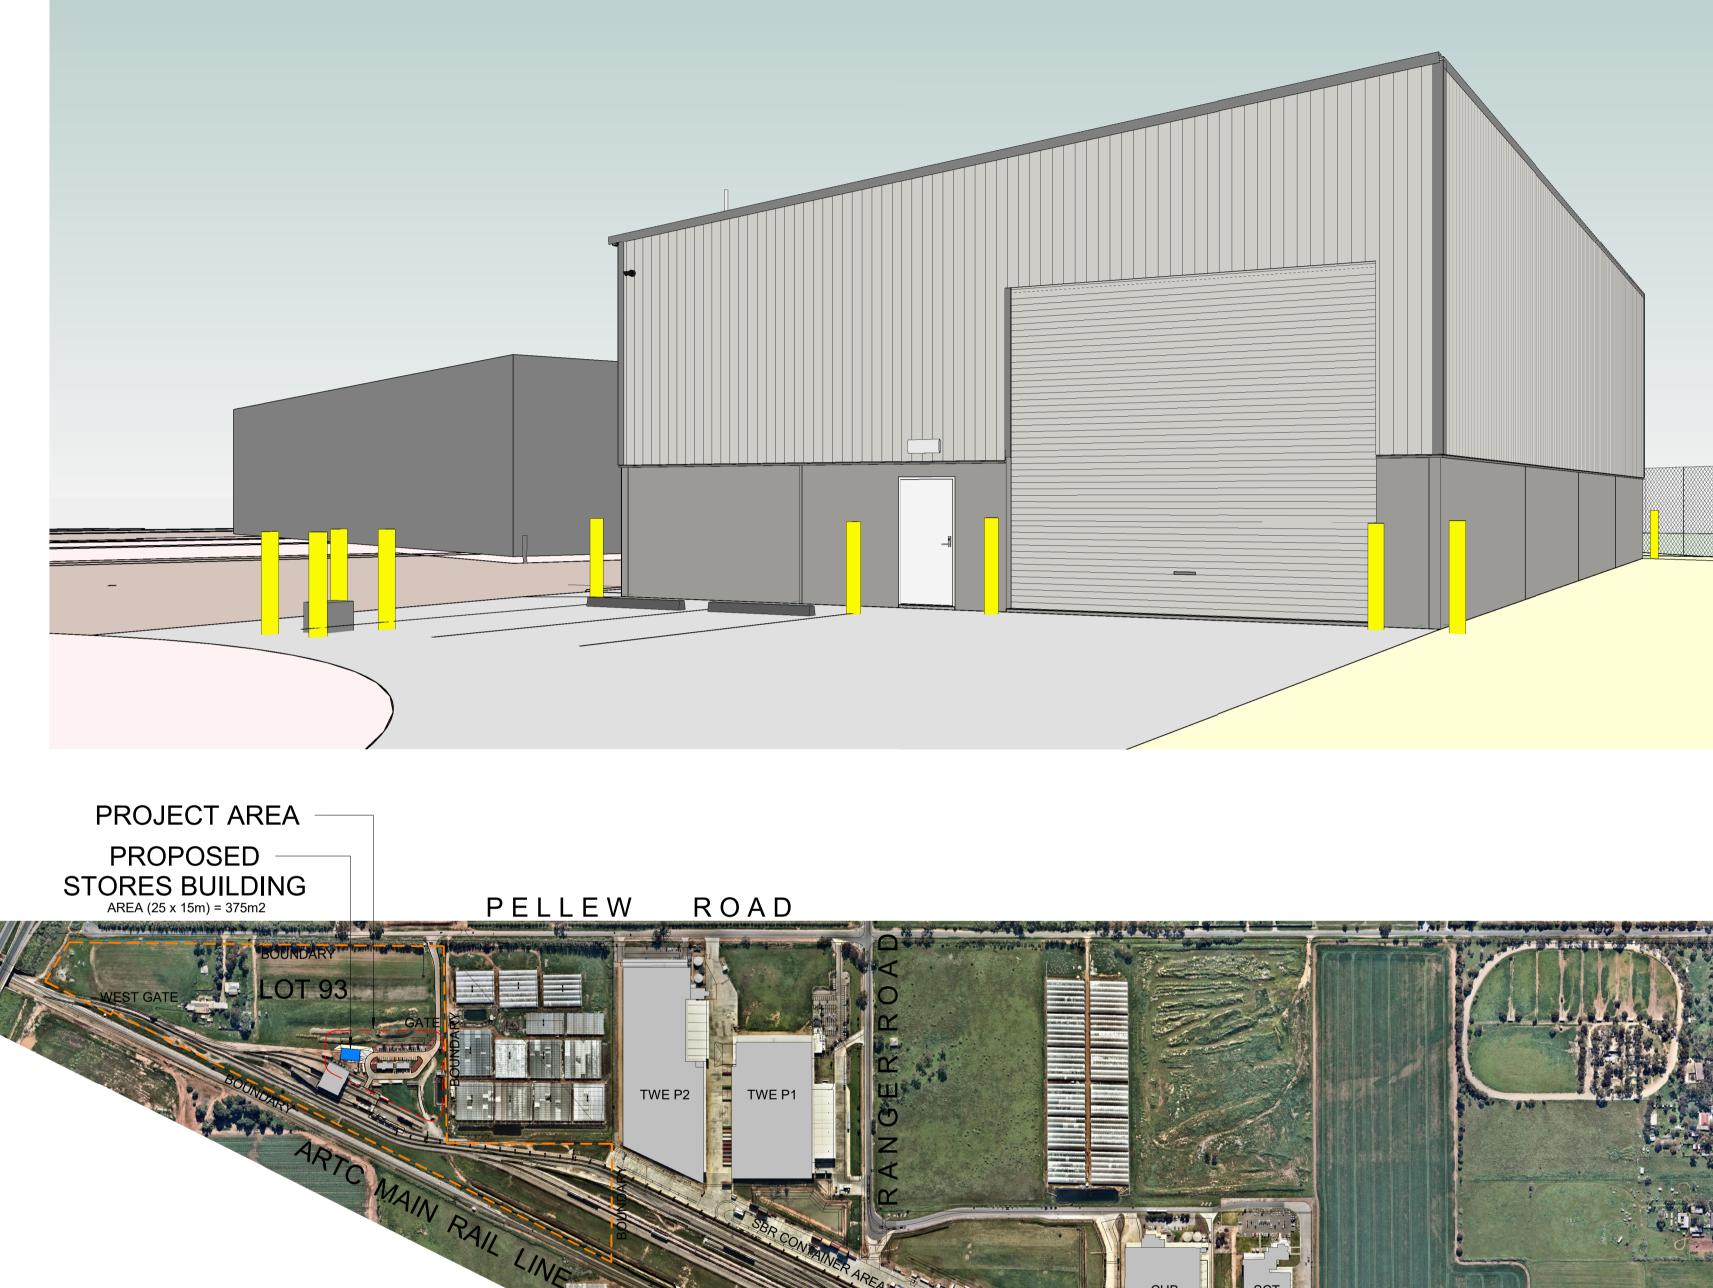

Site Location Plan

Lot 93 Pellew Road, Penfield. SA

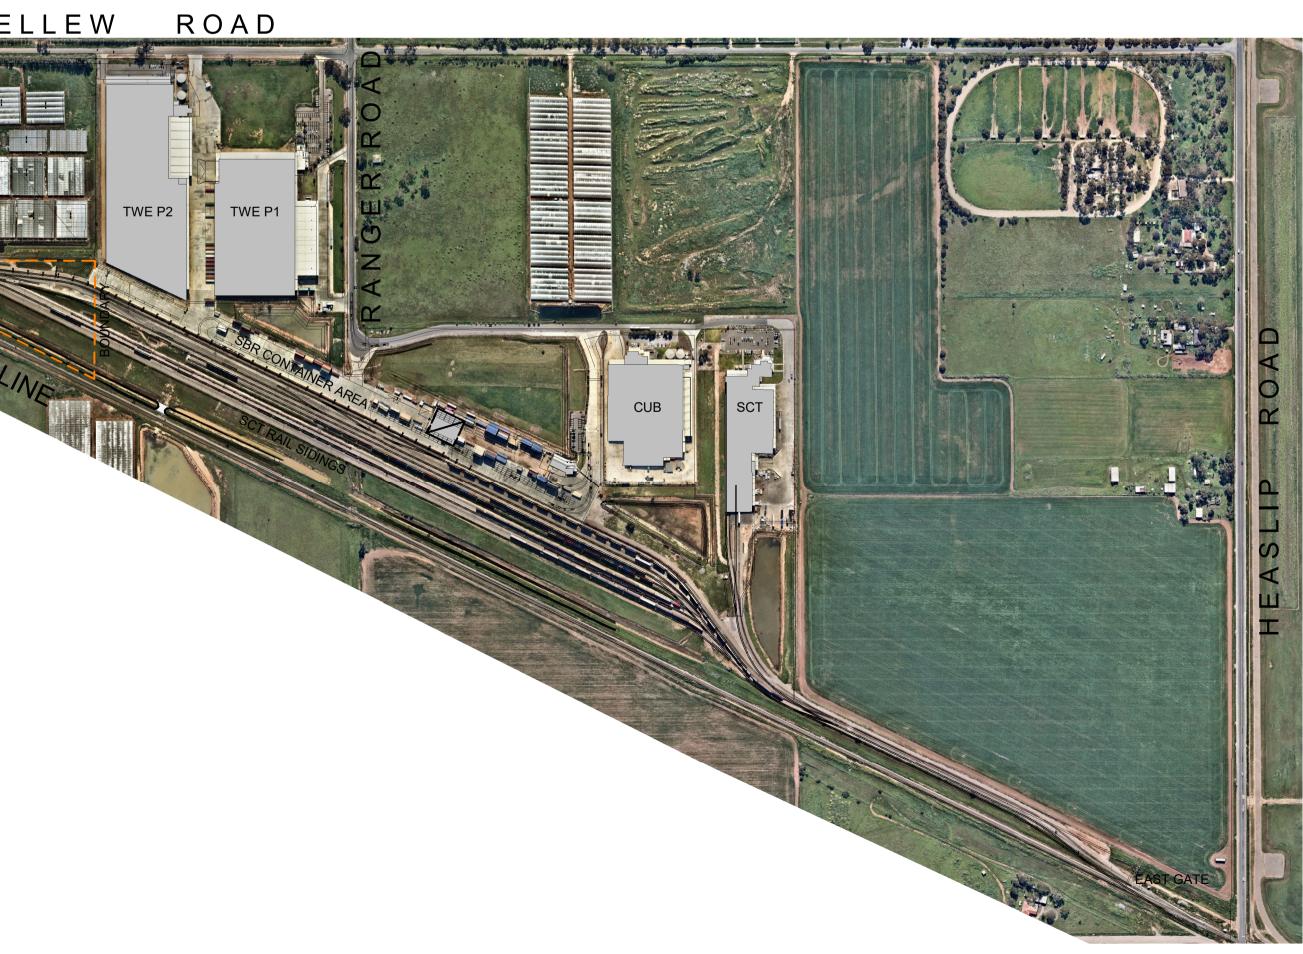

| Number | Rev. | Sheet Name |
|----------------------|------|--------------------------------|
| - le liter e trans l | | |
| rchitectural | | |
| A0 | Α | DRAWING REGISTER |
| A01 | Α | SITE PLAN - PART |
| A02 | Α | GROUND FLOOR PLAN |
| A03 | Α | ROOF & CEILING PLANS |
| A05 | Α | EXTERNAL ELEVATIONS |
| A06 | Α | SECTION SHEET |
| A07-1 | Α | PLAN DETAIL SHEET |
| A07-2 | Α | SECTION DETAIL SHEET 1 |
| A07-3 | Α | SECTION DETAIL SHEET 2 |
| A09-1 | Α | WET AREA DETAILS |
| A09-2 | Α | WET AREA SETOUT PLANS |
| A12 | Α | JOINERY DETAILS |
| A13 | Α | DOOR & WINDOW SCHEDULE |
| ectrical | | |
| E01 | Α | ELECTRICAL - POWER & DATA PLAN |
| E02 | Α | ELECTRICAL - LIGHTING PLAN |
| ydraulics | | |
| H01 | Α | HYDRAULICS PLANS |
| echanical | | |
| M01 | Α | GROUND FLOOR MECHANICAL PLAN |
| M02 | Α | MECHANICAL DETAILS |







16-22 Erudina Ave, Edwardstown S.A. 5039 Ph (08) 8277 0111 Industrial - Commercial - Educational <u>Date : 11/10/21</u> Drawn : TB

 Scale :
 1 : 5000 (@ A1) or
 (@ A3)

 Project Number :
 0555

 YRIGHT Drawing Number :
 A0.A

© COPYRIGHT Drawing Number : AU, Contractors must verify all dimensions at the job

Not for Construction until approved by Statutory Authorities before commencing work or making shop drawings.